

MAP GRID		MGA 56	
FIELD SUMMARY			
PIPE SIZE	LENGTH	ITEM	TOTAL
HORIZ WELL			
63mm	0	⊗	0
90mm	0	⊗	0
110mm	0	⊗	0
125mm	0	⊗	0
160mm	0	⊗	0
200mm	0	⊗	0
FLOW			
63mm	0	★	0
90mm	70	★	0
110mm	0	★	0
125mm	0	★	0
90mm	0	★	0
125mm	0	★	0
160mm	0	★	0
200mm	0	★	0
32mm	0	★	0
LATERAL			
63mm	0	⊗	0
90mm	0	⊗	0
125mm	0	⊗	0
160mm	0	⊗	0
200mm	0	⊗	0
LEACHATE AIR			
63mm	0	⊗	0
90mm	0	⊗	0
125mm	130	⊗	0
160mm	0	⊗	0
200mm	0	⊗	0
225mm	0	⊗	0
250mm	0	⊗	0
280mm	0	⊗	0
315mm	0	⊗	0
355mm	0	⊗	0
400mm	0	⊗	0
450mm	0	⊗	0
500mm	0	⊗	0
MAIN HEADER			
63mm	0	⊗	0
90mm	0	⊗	0
125mm	0	⊗	0
160mm	0	⊗	0
200mm	0	⊗	0
225mm	0	⊗	0
250mm	0	⊗	0
280mm	0	⊗	0
315mm	0	⊗	0
355mm	0	⊗	0
400mm	0	⊗	0
450mm	0	⊗	0
500mm	0	⊗	0

LEGEND	
⊗	WELL
⊗	MONITORING BORE
⊗	WELLHEAD STATION - STANDARD
⊗	J TRAP
★	BAROMETRIC TRAP
⊗	ISOLATION VALVE
⊗	PIT PUMPOUT
⊗	LEACHATE SUMP / RISER PIPES
⊗	STANDALONE WELL
⊗	KNOCKOUT POT
⊗	DUAL PURPOSE WELL
⊗	FLARE/POWER STATION
⊗	WELLHEAD STATION NAME
⊗	WELL NUMBER
⊗	MP1-1
⊗	MAIN GAS PIPE
⊗	GAS MONITORING BORE
⊗	LEACHATE RISER
⊗	METER RUN

---	FENCE LINE
---	CELL BOUNDARY
---	COMMUNICATION
---	POWER
---	63mm FLOW LINE
---	32mm AIR LINE
---	63mm AIR LINE
---	63mm LEACHATE LINE
---	90mm LEACHATE LINE
---	125mm LEACHATE LINE
---	160mm LEACHATE LINE
---	90mm HORIZONTAL WELL
---	90mm MAIN LATERAL HEADER
---	125mm MAIN LATERAL HEADER
---	160mm MAIN HEADER
---	200mm MAIN HEADER
---	225mm MAIN HEADER
---	250mm MAIN HEADER
---	280mm MAIN HEADER
---	315mm MAIN HEADER
---	355mm MAIN HEADER
---	400mm MAIN HEADER
---	450mm MAIN HEADER
---	500mm MAIN HEADER




REV	DESCRIPTION	BY	CHKD	APP	DATE
A	LEACHATE COLLECTION SYSTEM INSTALLATION	ZB	RC	RC	30/06/2022



PROJECT:	ERSKINE PARK LANDFILL GAS PROJECT
DRAWING TITLE:	LEACHATE COLLECTION SYSTEM INSTALLATION

DRAWING No:	RE-ERSKINE-001						
DRAWING TYPE:	DESIGN						
DRAWN:	ZB	CHKD:	RC				
DATE:	30/06/2022	APP:	RC				
DESIGNED:	RC	APP DATE:	30/06/2022				
SCALE:	1:400	SHEET:	1 of 1	REV:	A	SIZE:	A1

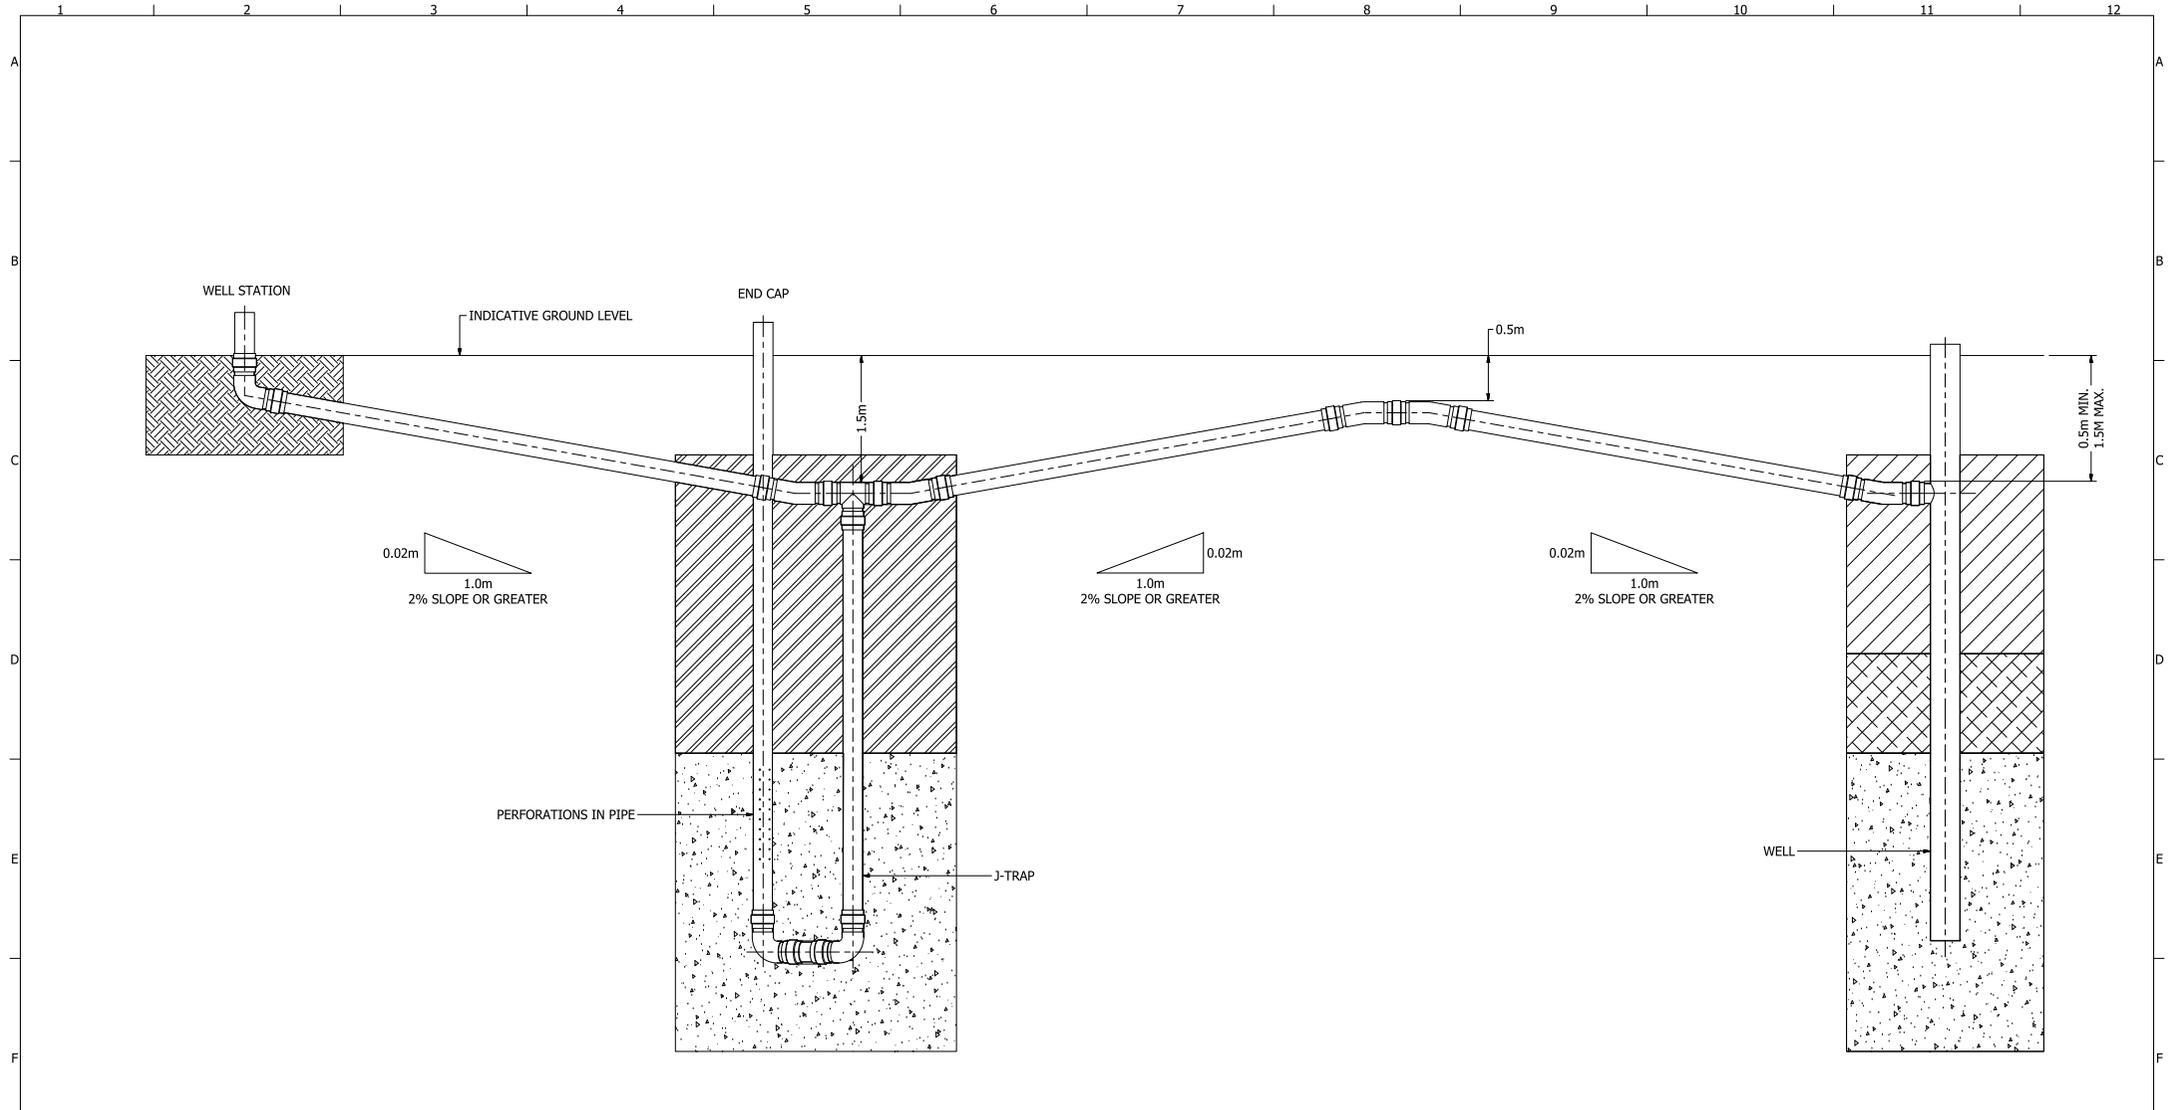


FRONT ELEVATION
SCALE (DNS)

REV	DESCRIPTION	BY	CHECKED	APPROVED	DATE
A	GENERAL ARRANGEMENT - FOR REVIEW	BC	LB	LB	5/10/2018

REVISION HISTORY

199C Osborne Avenue Clayton South, VIC, 3169 AUSTR. www.runenergy.com TEL: (03) 9538 6200					PROJECT RUN ENRGY GENERAL ARRANGEMENT	
DRAWN BC					DRAWING TITLE FLOW LINE INSTALLATION	
DATE 5/10/2018		DATE 5/10/2018		DATE 5/10/2018		
SCALE DNS			DRAWING NUMBER RE_LFG_002		SHEET 1 OF 1	
			REV A		SIZE A1	

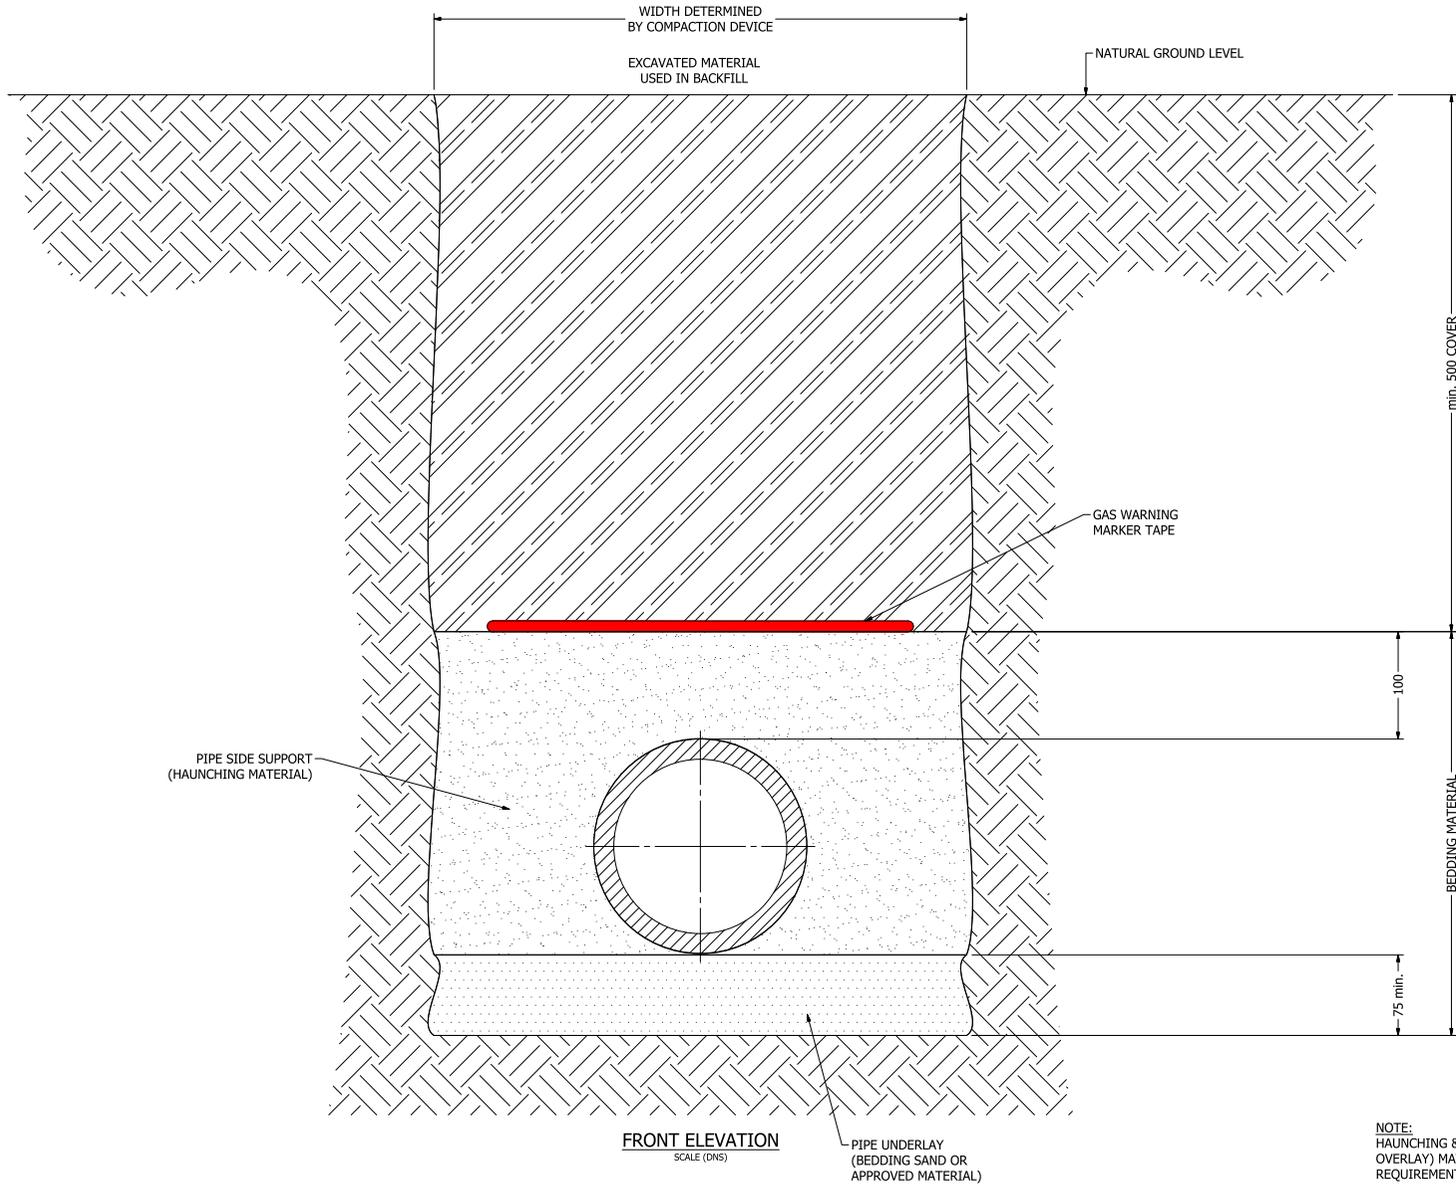


NOTE:
HAUNCHING & INITIAL BACKFILL (PIPE OVERLAY) MATERIAL TO COMPLY WITH REQUIREMENTS OF BEDDING MATERIAL.

A	GENERAL ARRANGEMENT - FOR REVIEW	BC	LB	LB	9/10/2018
REV	DESCRIPTION	BY	CHECKED	APPROVED	DATE

REVISION HISTORY

199C Osborne Avenue Clayton South, VIC, 3169 AUSTR. www.runenergy.com TEL: (03) 9538 6200					
DRAWN	BC	DESIGN	BC	APP	LB
DATE	9/10/2018	DATE	9/10/2018	DATE	9/10/2018

PROJECT RUN ENERGY GENERAL ARRANGEMENT					
DRAWING TITLE TRENCH DETAIL					
SCALE DNS	DRAWING NUMBER RE_LFG_006	SHEET 1 OF 1	REV A	SIZE A1	

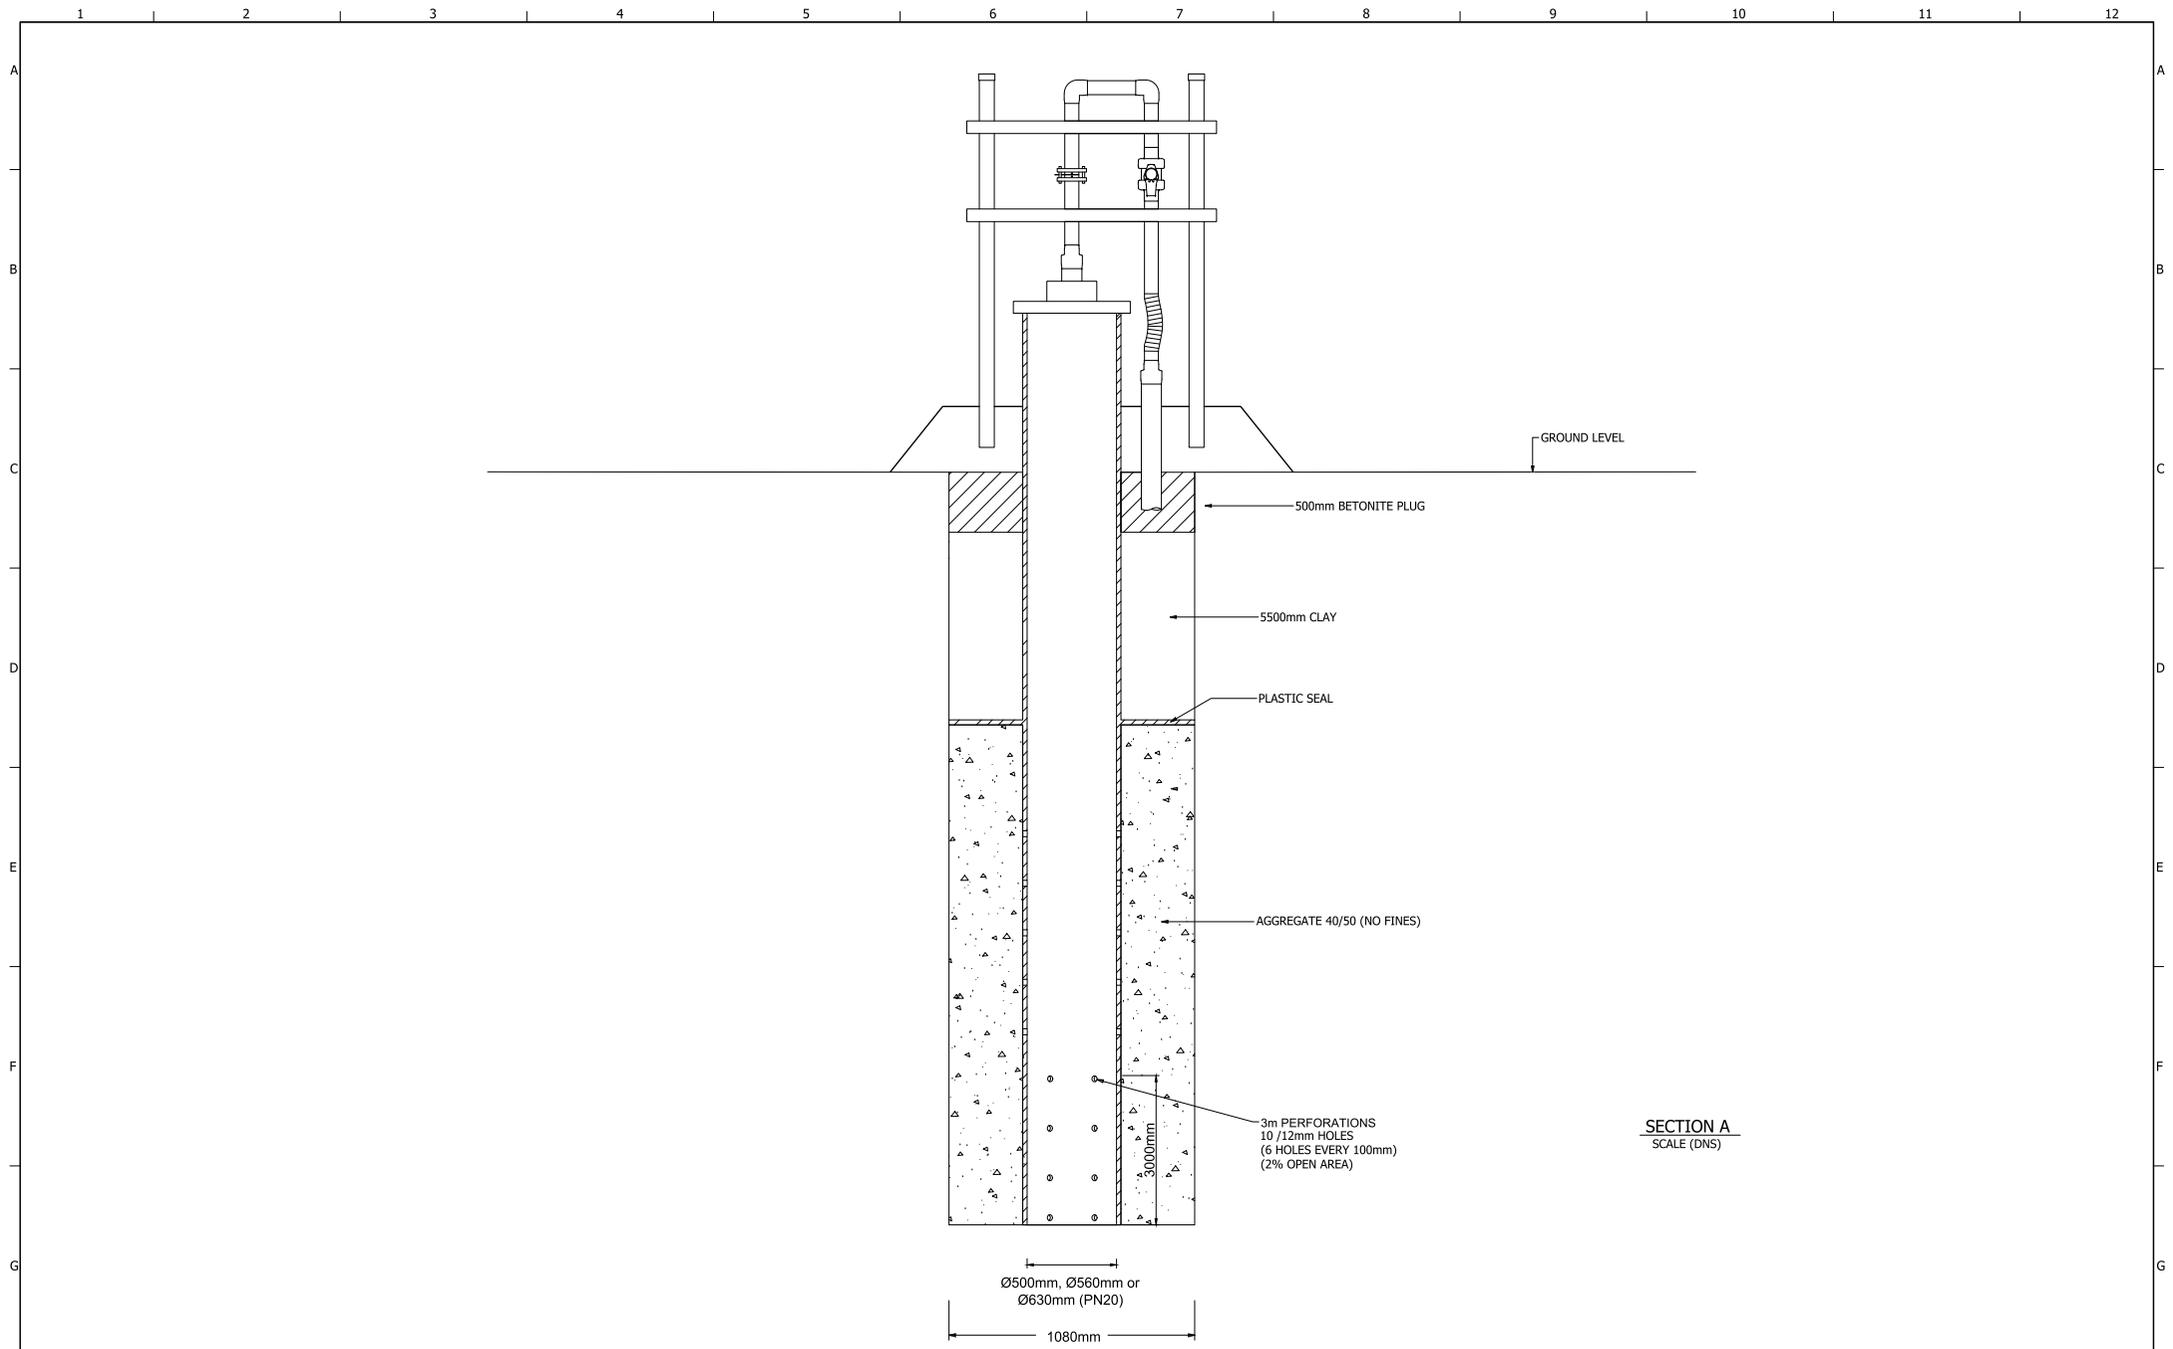

SECTION A
SCALE (DNS)

REV	DESCRIPTION	BY	CHECKED	APPROVED	DATE
A	GENERAL ARRANGEMENT - FOR REVIEW	ZB	RC	RC	30/06/2022
REVISION HISTORY					

runenergy

199C Osborne Avenue
Clayton South, VIC, 3169 AUSTR.
www.runenergy.com TEL: (03) 9538 6200

DRAWN	ZB	DESIGN	RC	APP	RC
DATE	30/06/2022	DATE	30/06/2022	DATE	30/06/2022

PROJECT		RUN ENERGY GENERAL ARRANGMENT			
DRAWING TITLE		ERSKINE PARK LEACHATE SUMP INSTALLATION			
SCALE	DRAWING NUMBER	SHEET	REV	SIZE	
DNS	RE-LFG-171	1 of 1	A	A1	